


1 SITE LIGHTING PLAN

N
I' = 60'-0"

Schedule												
Symbol	Label	Quantity	Manufacturer	Catalog Number	Description	Lamp	Number Lamps	Lumens Per Lamp	Lumen Multiple	Light Loss Factor	Wattage	Efficiency
□	A	2	Lithonia Lighting	DSX2 LED P3 40K T5W	DSX2 LED P3 40K T5W MVOLT	LED	1	29142	1	0.9	217	100%
□	C	0	Lithonia Lighting	DSX2 LED P2 40K TFTM HS	DSX2 LED P2 40K TFTM MVOLT with houseside shield	LED	1	18779	1	0.9	185	100%
□	D	3	Lithonia Lighting	DSX2 LED P2 40K T5W	DSX2 LED P2 40K T5W MVOLT	LED	1	24808	1	0.9	370	100%
□	I	3	Lithonia Lighting	DSX1 LED P4 40K TFTM WBA DSX2BBW	DSX1 LED P4 40K TFTM MVOLT	LED	1	14487	1	0.9	125	100%

Statistics						
Description	Symbol	Avg	Max	Min	Max/Min	Avg/Min
SITE	+	1.6 fc	4.4 fc	0.0 fc	N/A	N/A

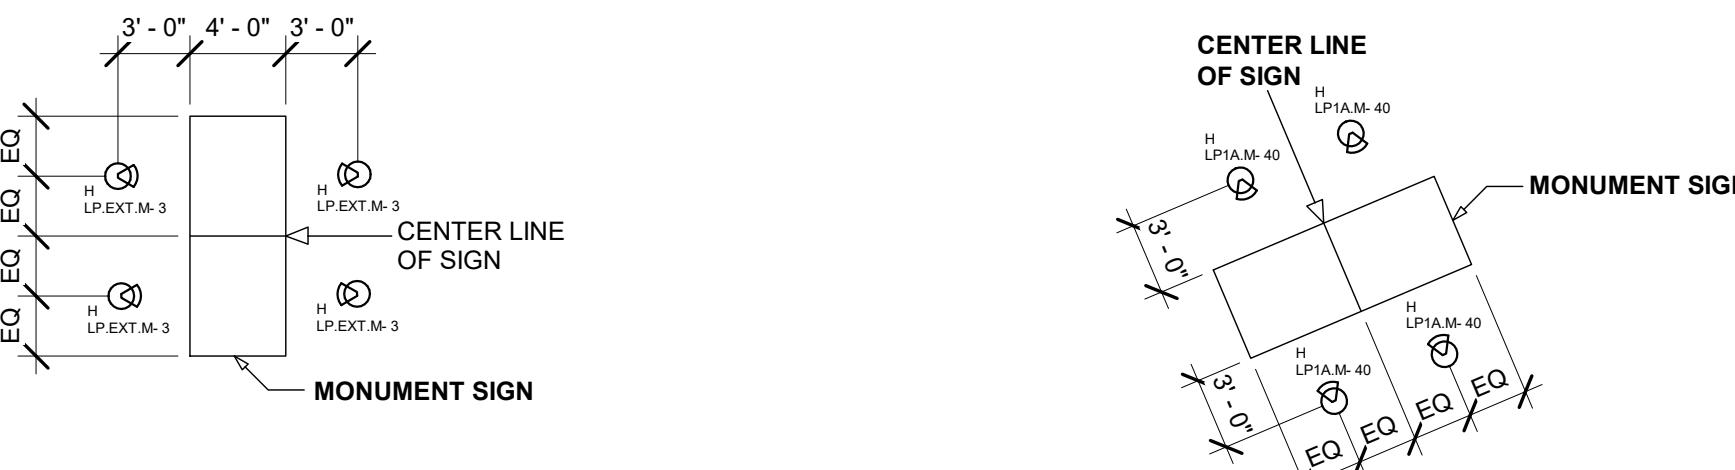

3 SITE LIGHTING PLAN - MONUMENT SIGN 1

4 SITE LIGHTING PLAN - MONUMENT SIGN 2

THE LIGHTING DESIGN WAS CREATED BY CITY LIGHTING, INCLUDING ALL FIXTURES, POLE SELECTION, LAYOUT, AND LIGHTING CONTROLS. CONTRACTOR SHALL CONTACT CITY LIGHTING OR CED FOR ALL LIGHTING. ALL LIGHTING FIXTURES AND LIGHT CONTROL PANELS SHALL BE SOURCED EXCLUSIVELY THROUGH CITY LIGHTING OR CED. NO SUBSTITUTIONS ACCEPTED.
CONTACT INFORMATION IS BELOW:

CITY LIGHTING:

**GARY MAGRENI, MANAGER/PM:
(704) 235-3134
GMAGRENI@CITYLIGHTING.COM**

**MIKE TURNEY, PJM
(704) 235-3135
MTURNEY@CITYLIGHTING.COM**

CED:

**SARAH DEVLIN
(206)694-6495
CEDFC@CED.COM**

**GREG APPLEGATE, CED NATIONAL ACCOUNTS
(206)793-1906
GREG.APPLEGATE@CED.COM**

C.O.A. #26759
HILSON IRGENTI
ENGINEERING
200 E. ROBINSON STREET, STE. 970
ORLANDO, FL 32801
WORKWITHWG.COM
813.855.3330

ALL IDEAS, DESIGNS, ARRANGEMENTS AND PLANS INDICATED OR REPRESENTED BY THIS DRAWING ARE OWNED BY AND THE PROPERTY OF BAKER BARRIOS ARCHITECTS, INC. AND WERE CREATED, EXPENDED, AND DEVELOPED FOR USE ON AND IN CONNECTION WITH THE SPECIFIED PROJECT. NONE OF THE IDEAS, DESIGNS, ARRANGEMENTS OR PLANS SHOWN HEREIN MAY BE USED, REPRODUCED, COPIED, OR COMMUNICATED FOR ANY PURPOSE WHATSOEVER WITHOUT THE WRITTEN PERMISSION OF BAKER BARRIOS ARCHITECTS, INC. BAKING OR REPRODUCTION HEREOF IS A CRIMINAL OFFENSE UNDER 18 U.S.C. SEC. 506 UNAUTHORIZED DISCLOSURE MAY RESULT IN FINE AND/OR IMPRISONMENT. THE INFORMATION CONTAINED HEREIN IS CONFIDENTIAL. THE IDEAS, ARRANGEMENTS AND DESIGNS DISCLOSED HEREIN MAY BE PATENTED OR BE THE SUBJECT OF PENDING PATENT APPLICATION.

NO DATE REVISION/ SUBMISSION
03/09/2021 PERMIT SET

TO THE BEST OF THE ARCHITECT'S OR ENGINEER'S KNOWLEDGE AND ABILITY, THE PLANS AND SPECIFICATIONS COMPLY WITH THE APPLICABLE MINIMUM BUILDING CODES.

Baker Barrios
ORLANDO
189 S. ORANGE AVE., SUITE 1700
ORLANDO, FLORIDA 32801
407 926 3000
INFO@BAKERBARRIOS.COM
BAKERBARRIOS.COM
AA0002981 | LC26000427 | COA36020

TENANT IMPROVEMENT
1301 PRESIDENT BARACK OBAMA HWY,
RIVIERA BEACH, FL 33404

OVERALL LIGHTING PLAN - SITE

PROJECT NO: 200166.00 SHEET NUMBER: **E0.10**

E0.10

200166.00

4/12/2021 9:39:21 PM